


APPENDIX E

Water System Proposed Layouts

Wastewater System Proposed Layouts

Power, Gas & Communications Layout


C:\Projects\9480-Ravalli County TEDD PERC\04000440 AERIAL\0400.dwg, 11/18/15

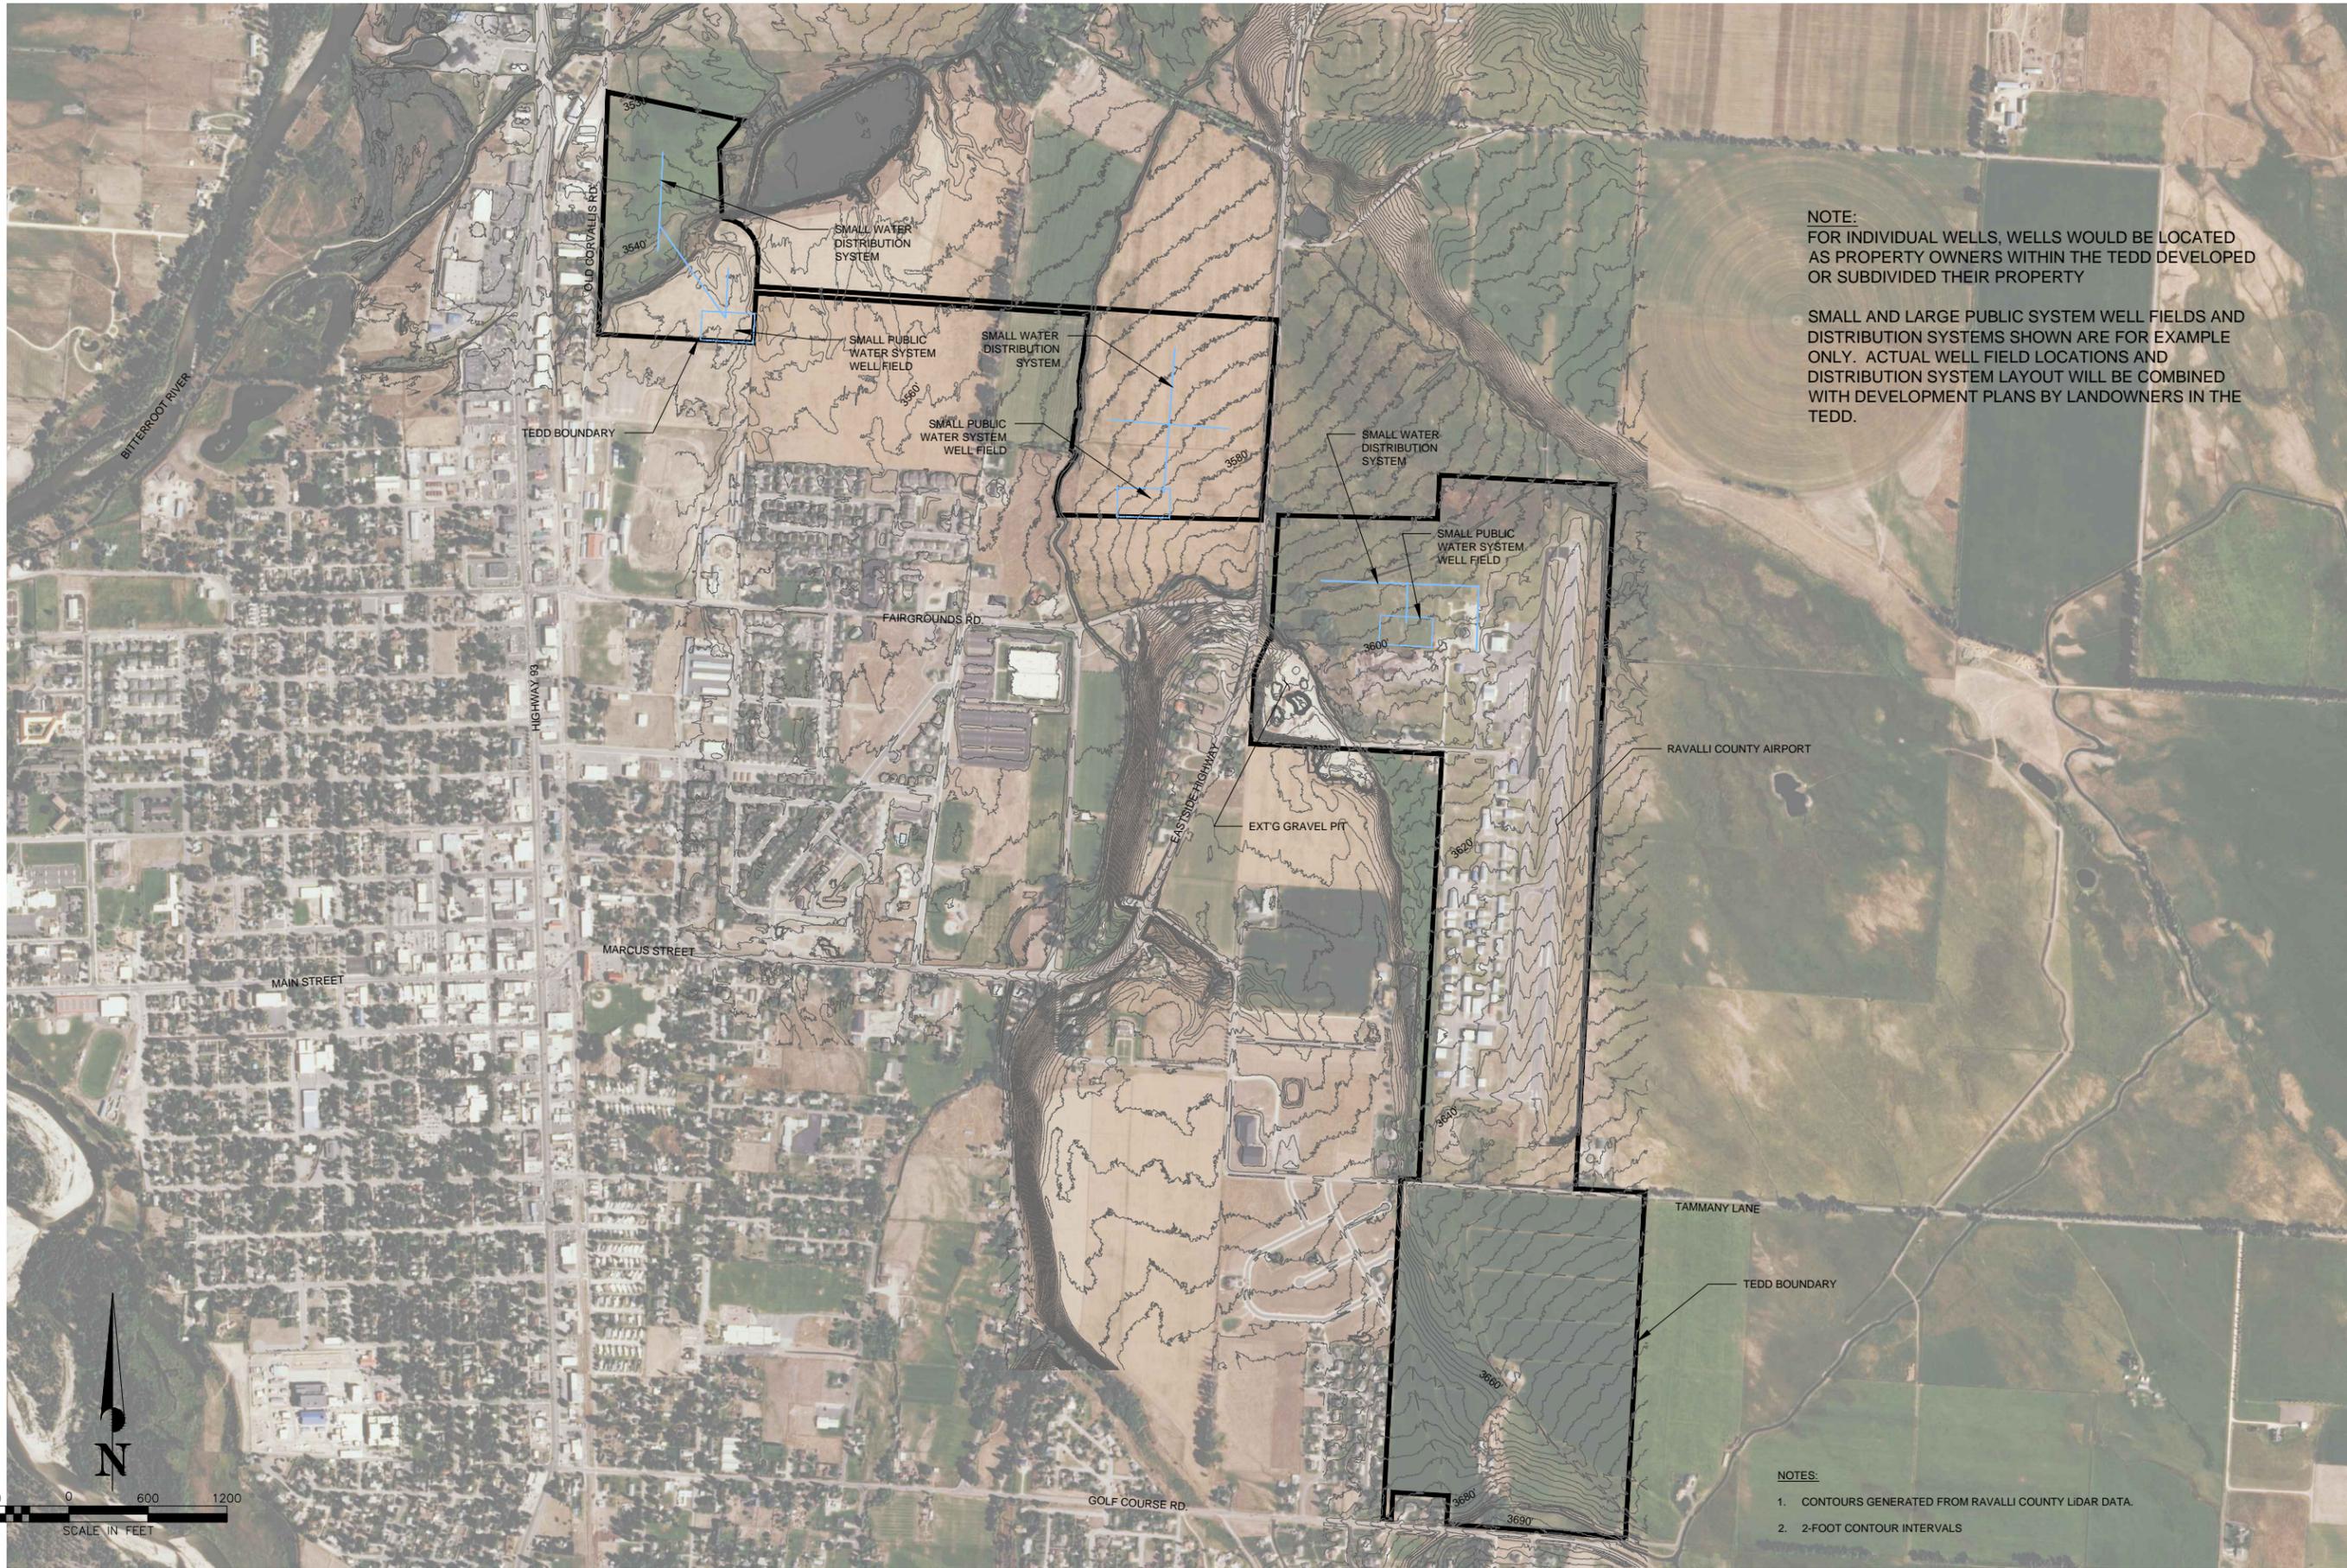

NOTE:
FOR INDIVIDUAL WELLS, WELLS WOULD BE LOCATED AS PROPERTY OWNERS WITHIN THE TEDD DEVELOPED OR SUBDIVIDED THEIR PROPERTY

SMALL AND LARGE PUBLIC SYSTEM WELL FIELDS AND DISTRIBUTION SYSTEMS SHOWN ARE FOR EXAMPLE ONLY. ACTUAL WELL FIELD LOCATIONS AND DISTRIBUTION SYSTEM LAYOUT WILL BE COMBINED WITH DEVELOPMENT PLANS BY LANDOWNERS IN THE TEDD.

- NOTES:
1. CONTOURS GENERATED FROM RAVALLI COUNTY LIDAR DATA.
 2. 2-FOOT CONTOUR INTERVALS

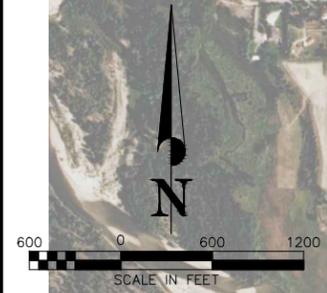

PROJECT #:	6480-13
DRAWN:	NEW
REVISION:	
CHECKED:	AM

WATER SYSTEM ALTERNATIVES
RAVALLI COUNTY TEDD
 RAVALLI COUNTY MONTANA

Professional Consultants Inc.
 Engineers, Surveyors, Planners, Mapmakers
 113 BERTH STREET
 HAMILTON, MONTANA 59801
 PHONE: 406-543-1310
 FAX: 406-543-1311
 OR 406-543-1315


NOVEMBER 2015

EXHIBIT

E.1

PER


C:\Projects\9480-Ravalli County TEDD PERC\00004840 AERIAL_QA04.dwg, 11/16/15

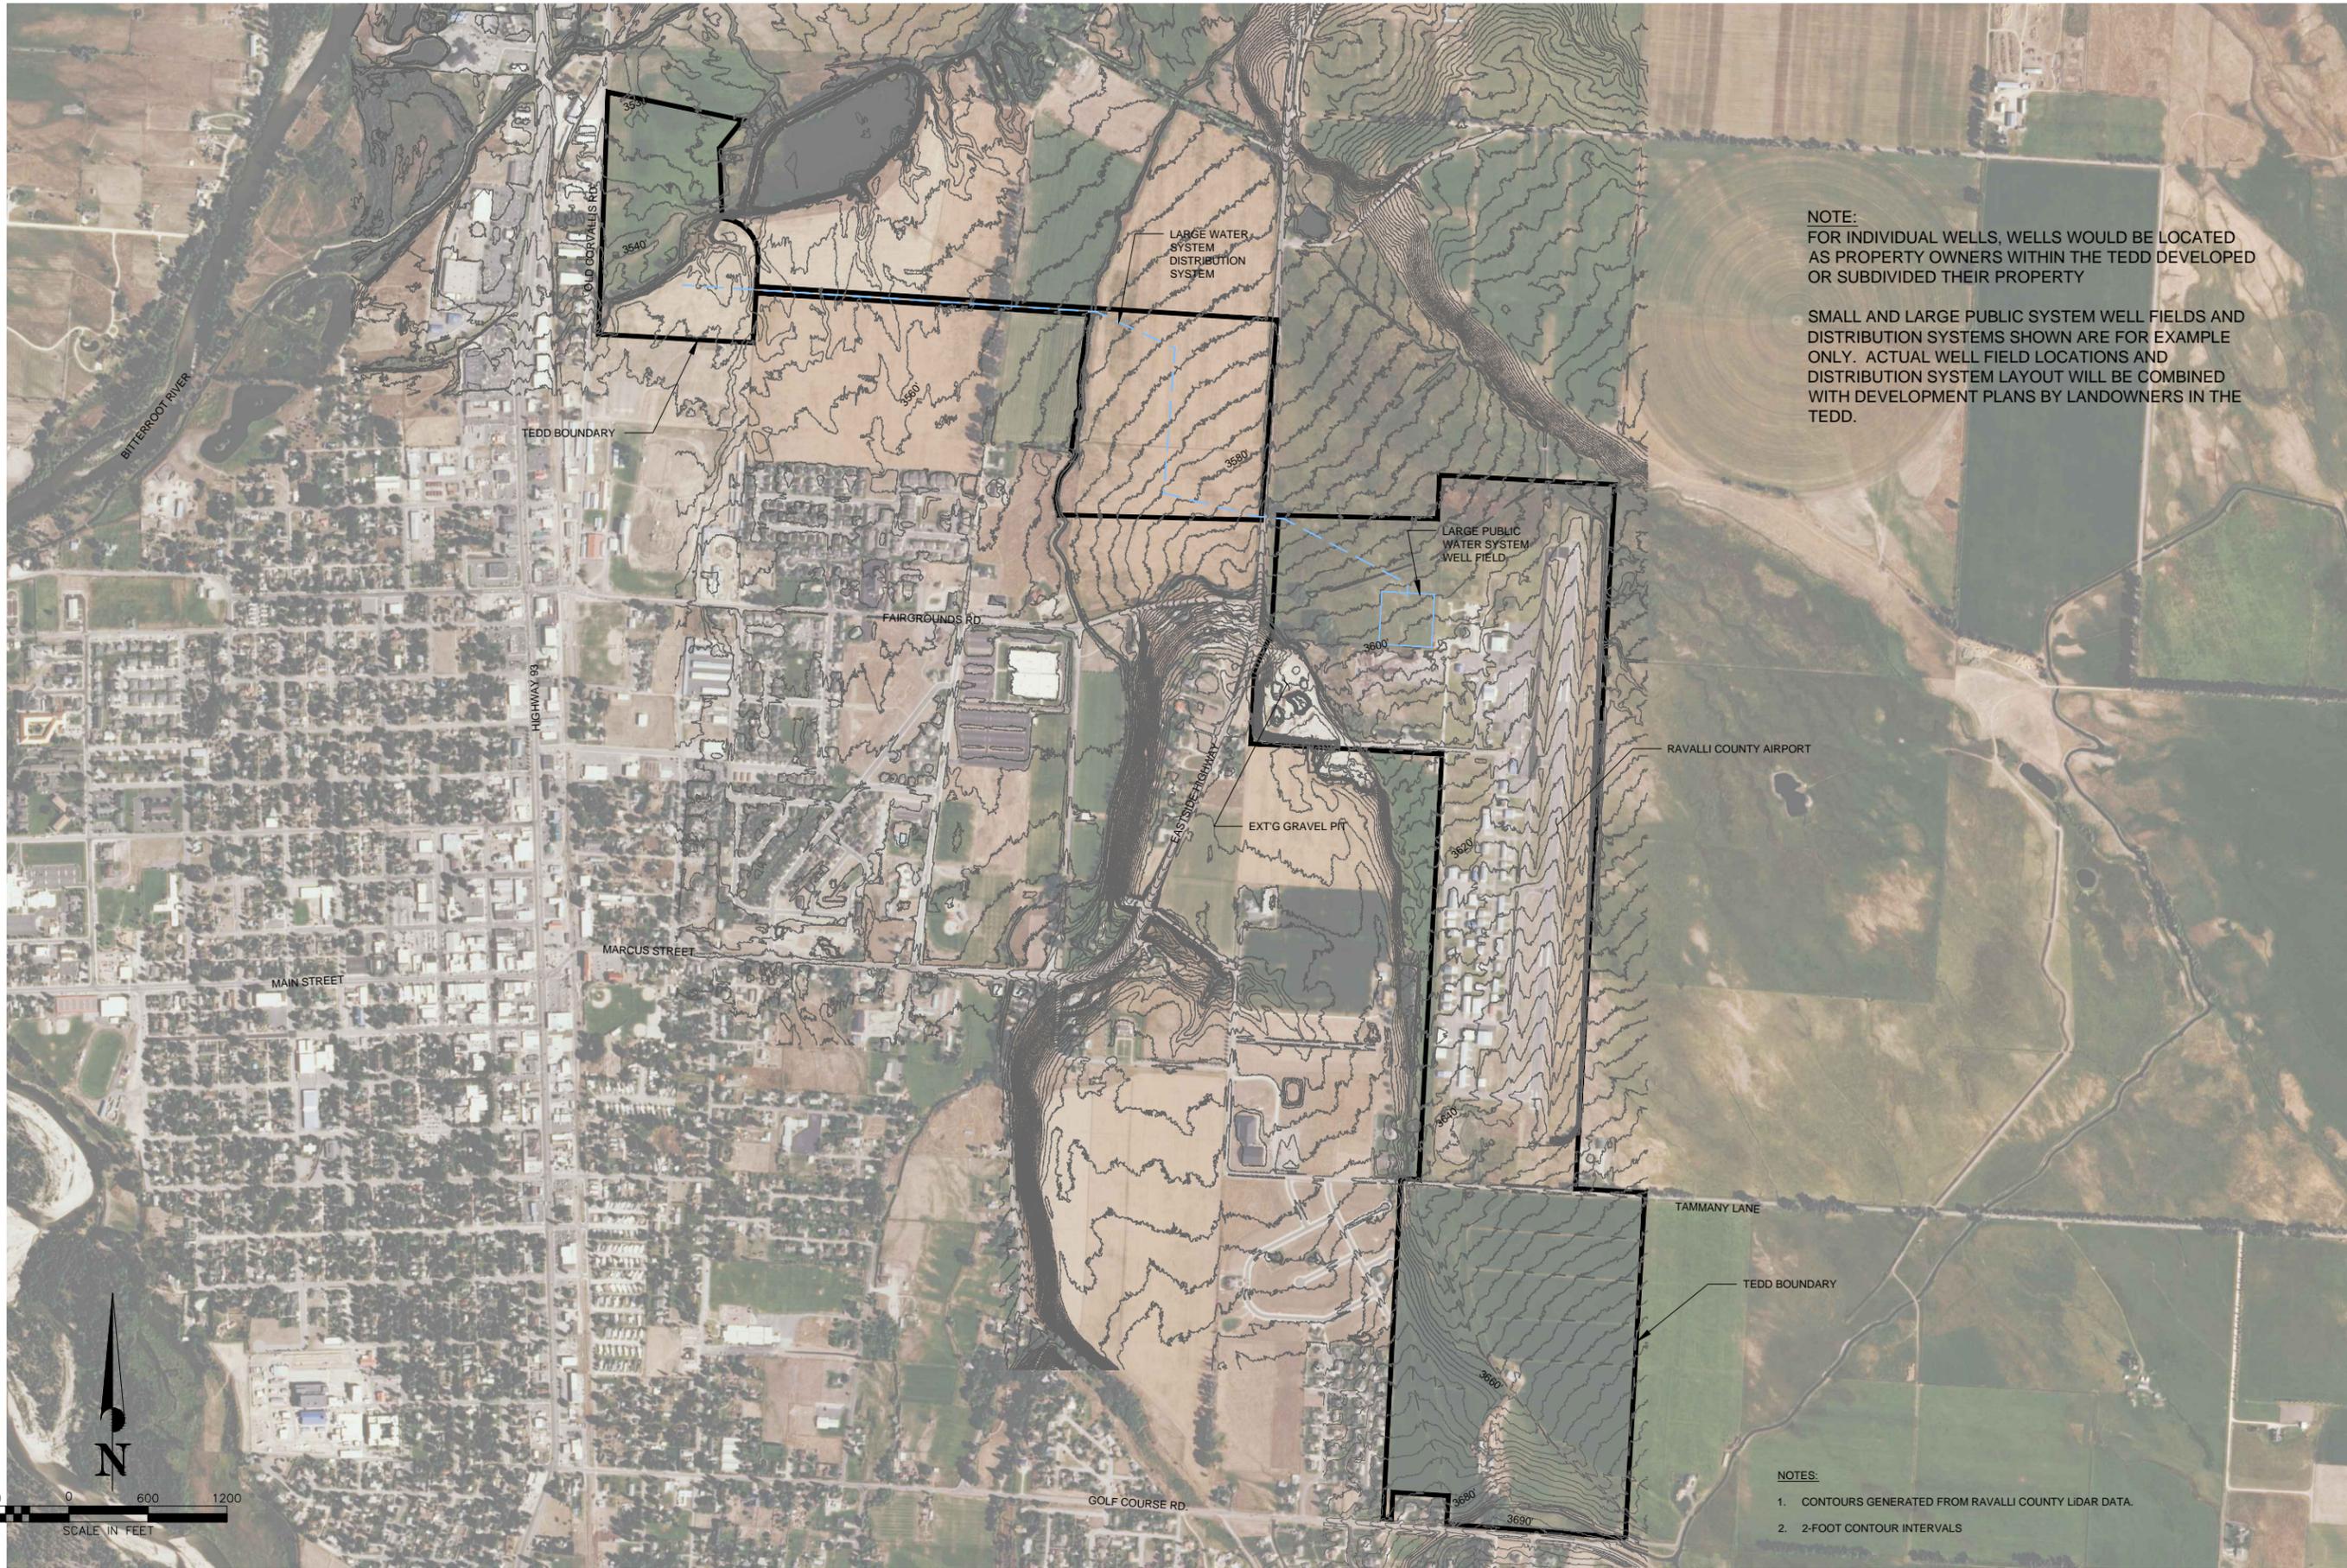

NOTE:
FOR INDIVIDUAL WELLS, WELLS WOULD BE LOCATED AS PROPERTY OWNERS WITHIN THE TEDD DEVELOPED OR SUBDIVIDED THEIR PROPERTY

SMALL AND LARGE PUBLIC SYSTEM WELL FIELDS AND DISTRIBUTION SYSTEMS SHOWN ARE FOR EXAMPLE ONLY. ACTUAL WELL FIELD LOCATIONS AND DISTRIBUTION SYSTEM LAYOUT WILL BE COMBINED WITH DEVELOPMENT PLANS BY LANDOWNERS IN THE TEDD.

- NOTES:
1. CONTOURS GENERATED FROM RAVALLI COUNTY LIDAR DATA.
 2. 2-FOOT CONTOUR INTERVALS

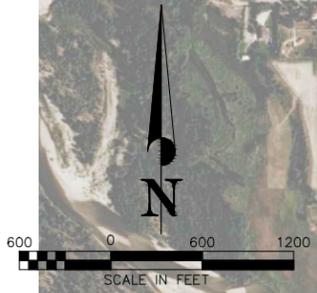

PROJECT #:	6480-13
DRAWN:	NEW
REVISION:	
CHECKED:	AM

WATER SYSTEM ALTERNATIVES
RAVALLI COUNTY TEDD
 RAVALLI COUNTY MONTANA

Professional Consultants Inc.
 Engineers, Surveyors, Planners, Mapmakers
 113 NORTH FIRST STREET
 HAMILTON, MONTANA 59801
 PHONE: 406-545-1300
 FAX: 406-545-1315
 OR 406-545-1315

NOVEMBER 2015

EXHIBIT

E.2

PER